


# CITY OF RICHMOND, VIRGINIA DEPARTMENT OF PUBLIC WORKS

# FIRE DEPARTMENT TRAINING FACILITY PROJECT

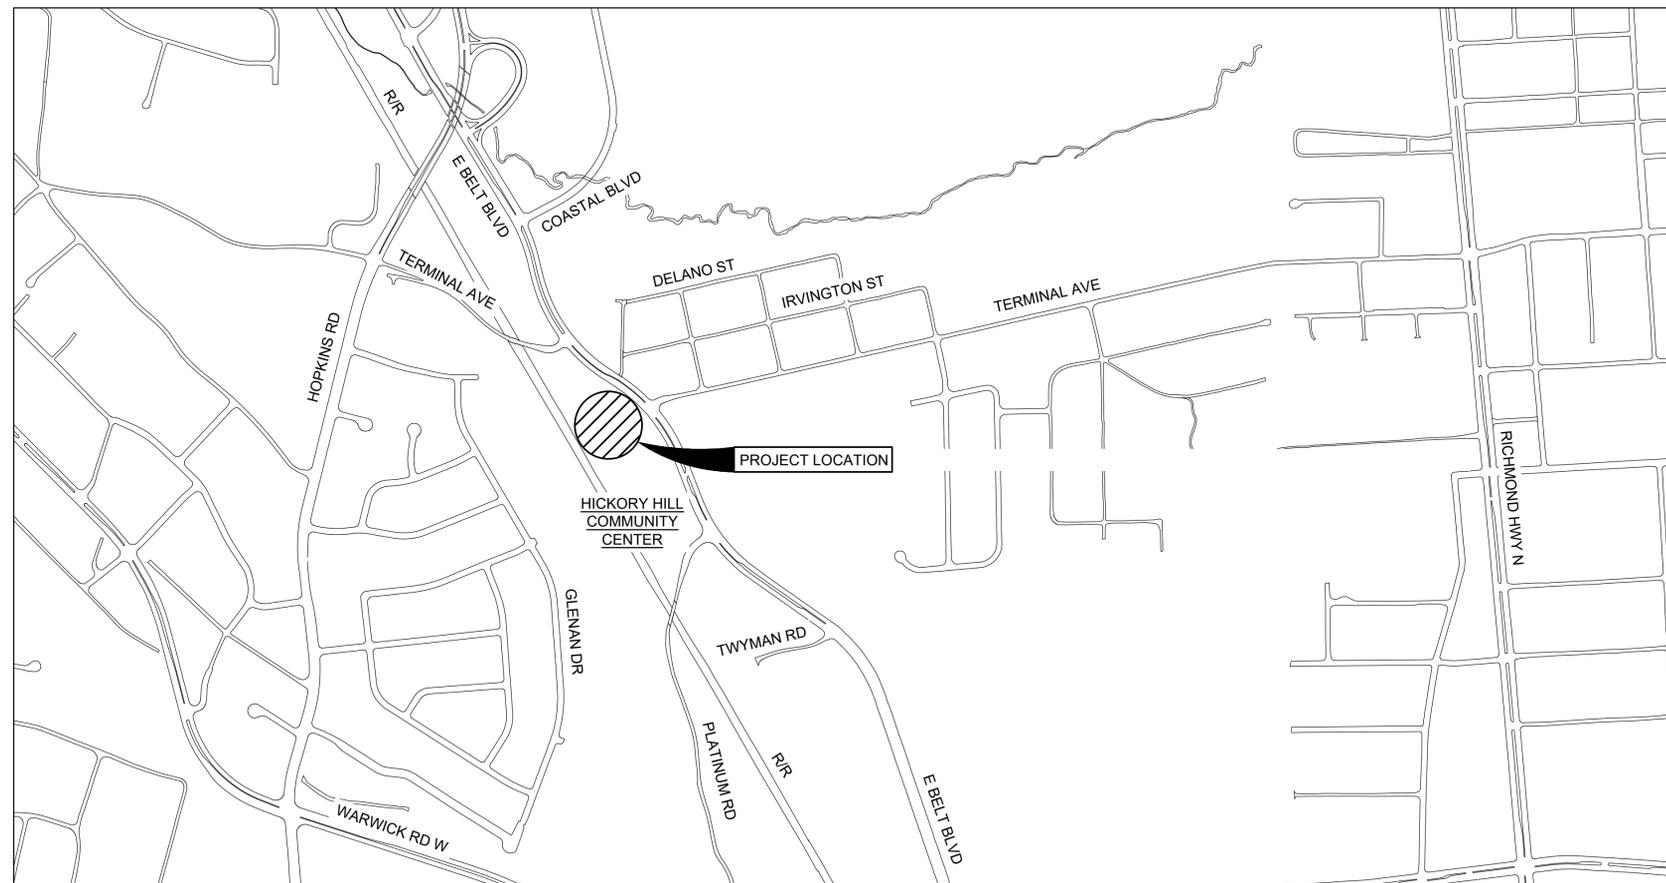

VICINITY MAP



## GREELEY AND HANSEN

9020 STONY POINT PARKWAY, SUITE 275  
RICHMOND, VIRGINIA 23235

IN ASSOCIATION WITH

**ECE** **Environ-Civil Engineering, Ltd.**  
 Engineers • Scientists • Construction Managers  
 2108 W Laburnum Avenue, Suite 250 Richmond, VA 23227

**DANIELS & ASSOCIATES, P.C.**  
*Consulting Engineers*  
 808 Moorefield Park Drive, Suite 105  
 Richmond, Virginia 23236

**PROJECT ADDRESS**

3000 EAST BELT BOULEVARD  
RICHMOND, VA 23234  
PARCEL ID: C0090612020

**OWNER CONTACT**


LOUIS D. GOODE  
CITY OF RICHMOND DEPARTMENT OF PUBLIC WORKS  
900 EAST BROAD STREET - RM. 602  
RICHMOND, VA 23219  
PHONE: (804) 646-7531

**DPU CONTACT**

LOUIS D. GOODE  
CITY OF RICHMOND DEPARTMENT OF PUBLIC WORKS  
900 EAST BROAD STREET - RM. 602  
RICHMOND, VA 23219  
PHONE: (804) 646-7531

NOVEMBER 2022

**90% SUBMITTAL**  
NOT FOR CONSTRUCTION

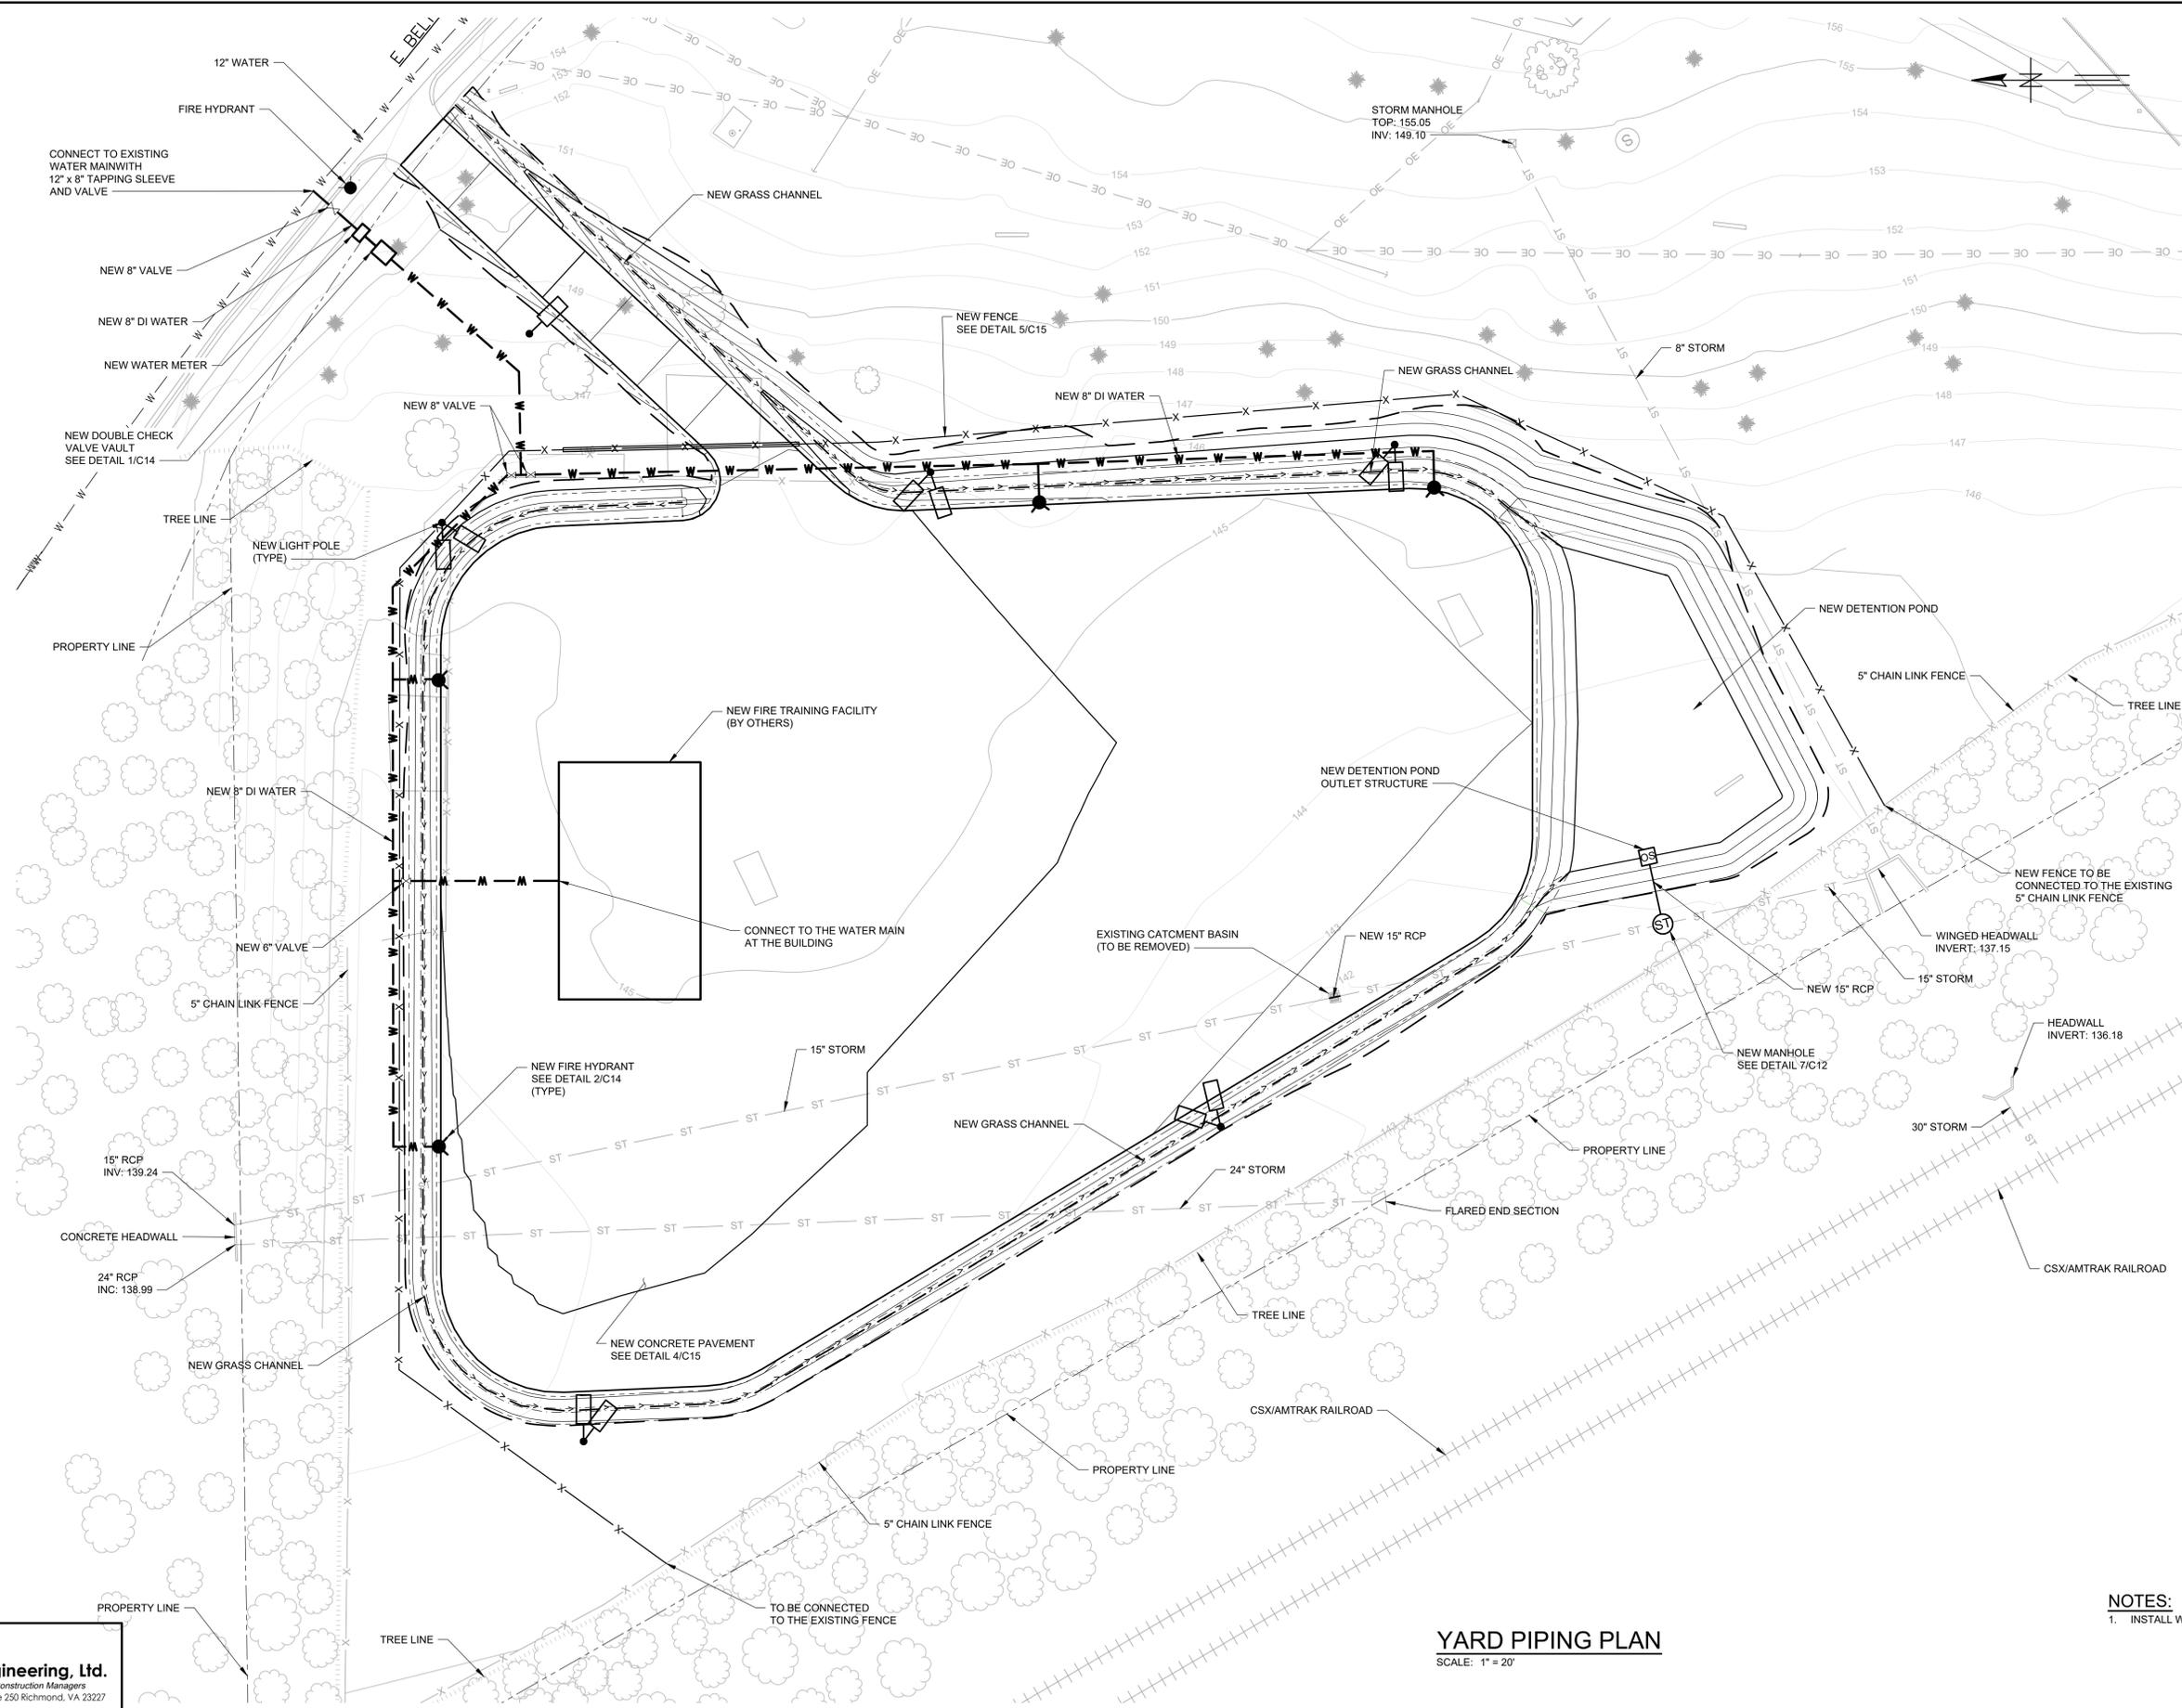


**NOTES:**  
 1. INSTALL WATER MAIN 3.5' (MIN) BELOW FINISHED GRADE

**YARD PIPING PLAN**  
 SCALE: 1" = 20'

**EC** Environ-Civil Engineering, Ltd.  
 Engineers • Scientists • Construction Managers  
 2108 W Laburnum Avenue, Suite 250 Richmond, VA 23227

**GREELEY AND HANSEN**  
 9020 STONY POINT PARKWAY, SUITE 275  
 RICHMOND, VIRGINIA 23235

DESIGNED	XXX				
DRAWN	XXX				
CHECKED	XXX				
APPROVED					
NO.	DATE	APPD	REVISION DESCRIPTION		

 


CITY OF RICHMOND, VIRGINIA  
 DEPARTMENT OF PUBLIC UTILITIES  
**RICHMOND FIRE DEPARTMENT**  
 TRAINING FACILITY



CIVIL	PROJECT NO.: 0218A-09
CIVIL YARD PIPING PLAN	DWG: <b>C11</b>
	SHEET: 13 OF XX
	DATE: NOVEMBER 2022 REV: 0

2022/11/14 4:13 PM

S:\0218\_RICHMOND\0218A\_09\_FIRE TRAINING FACILITY\04-DESIGN\CIVIL\3D\CDD0218A\_09\_C12.DWG HANCER, CAN

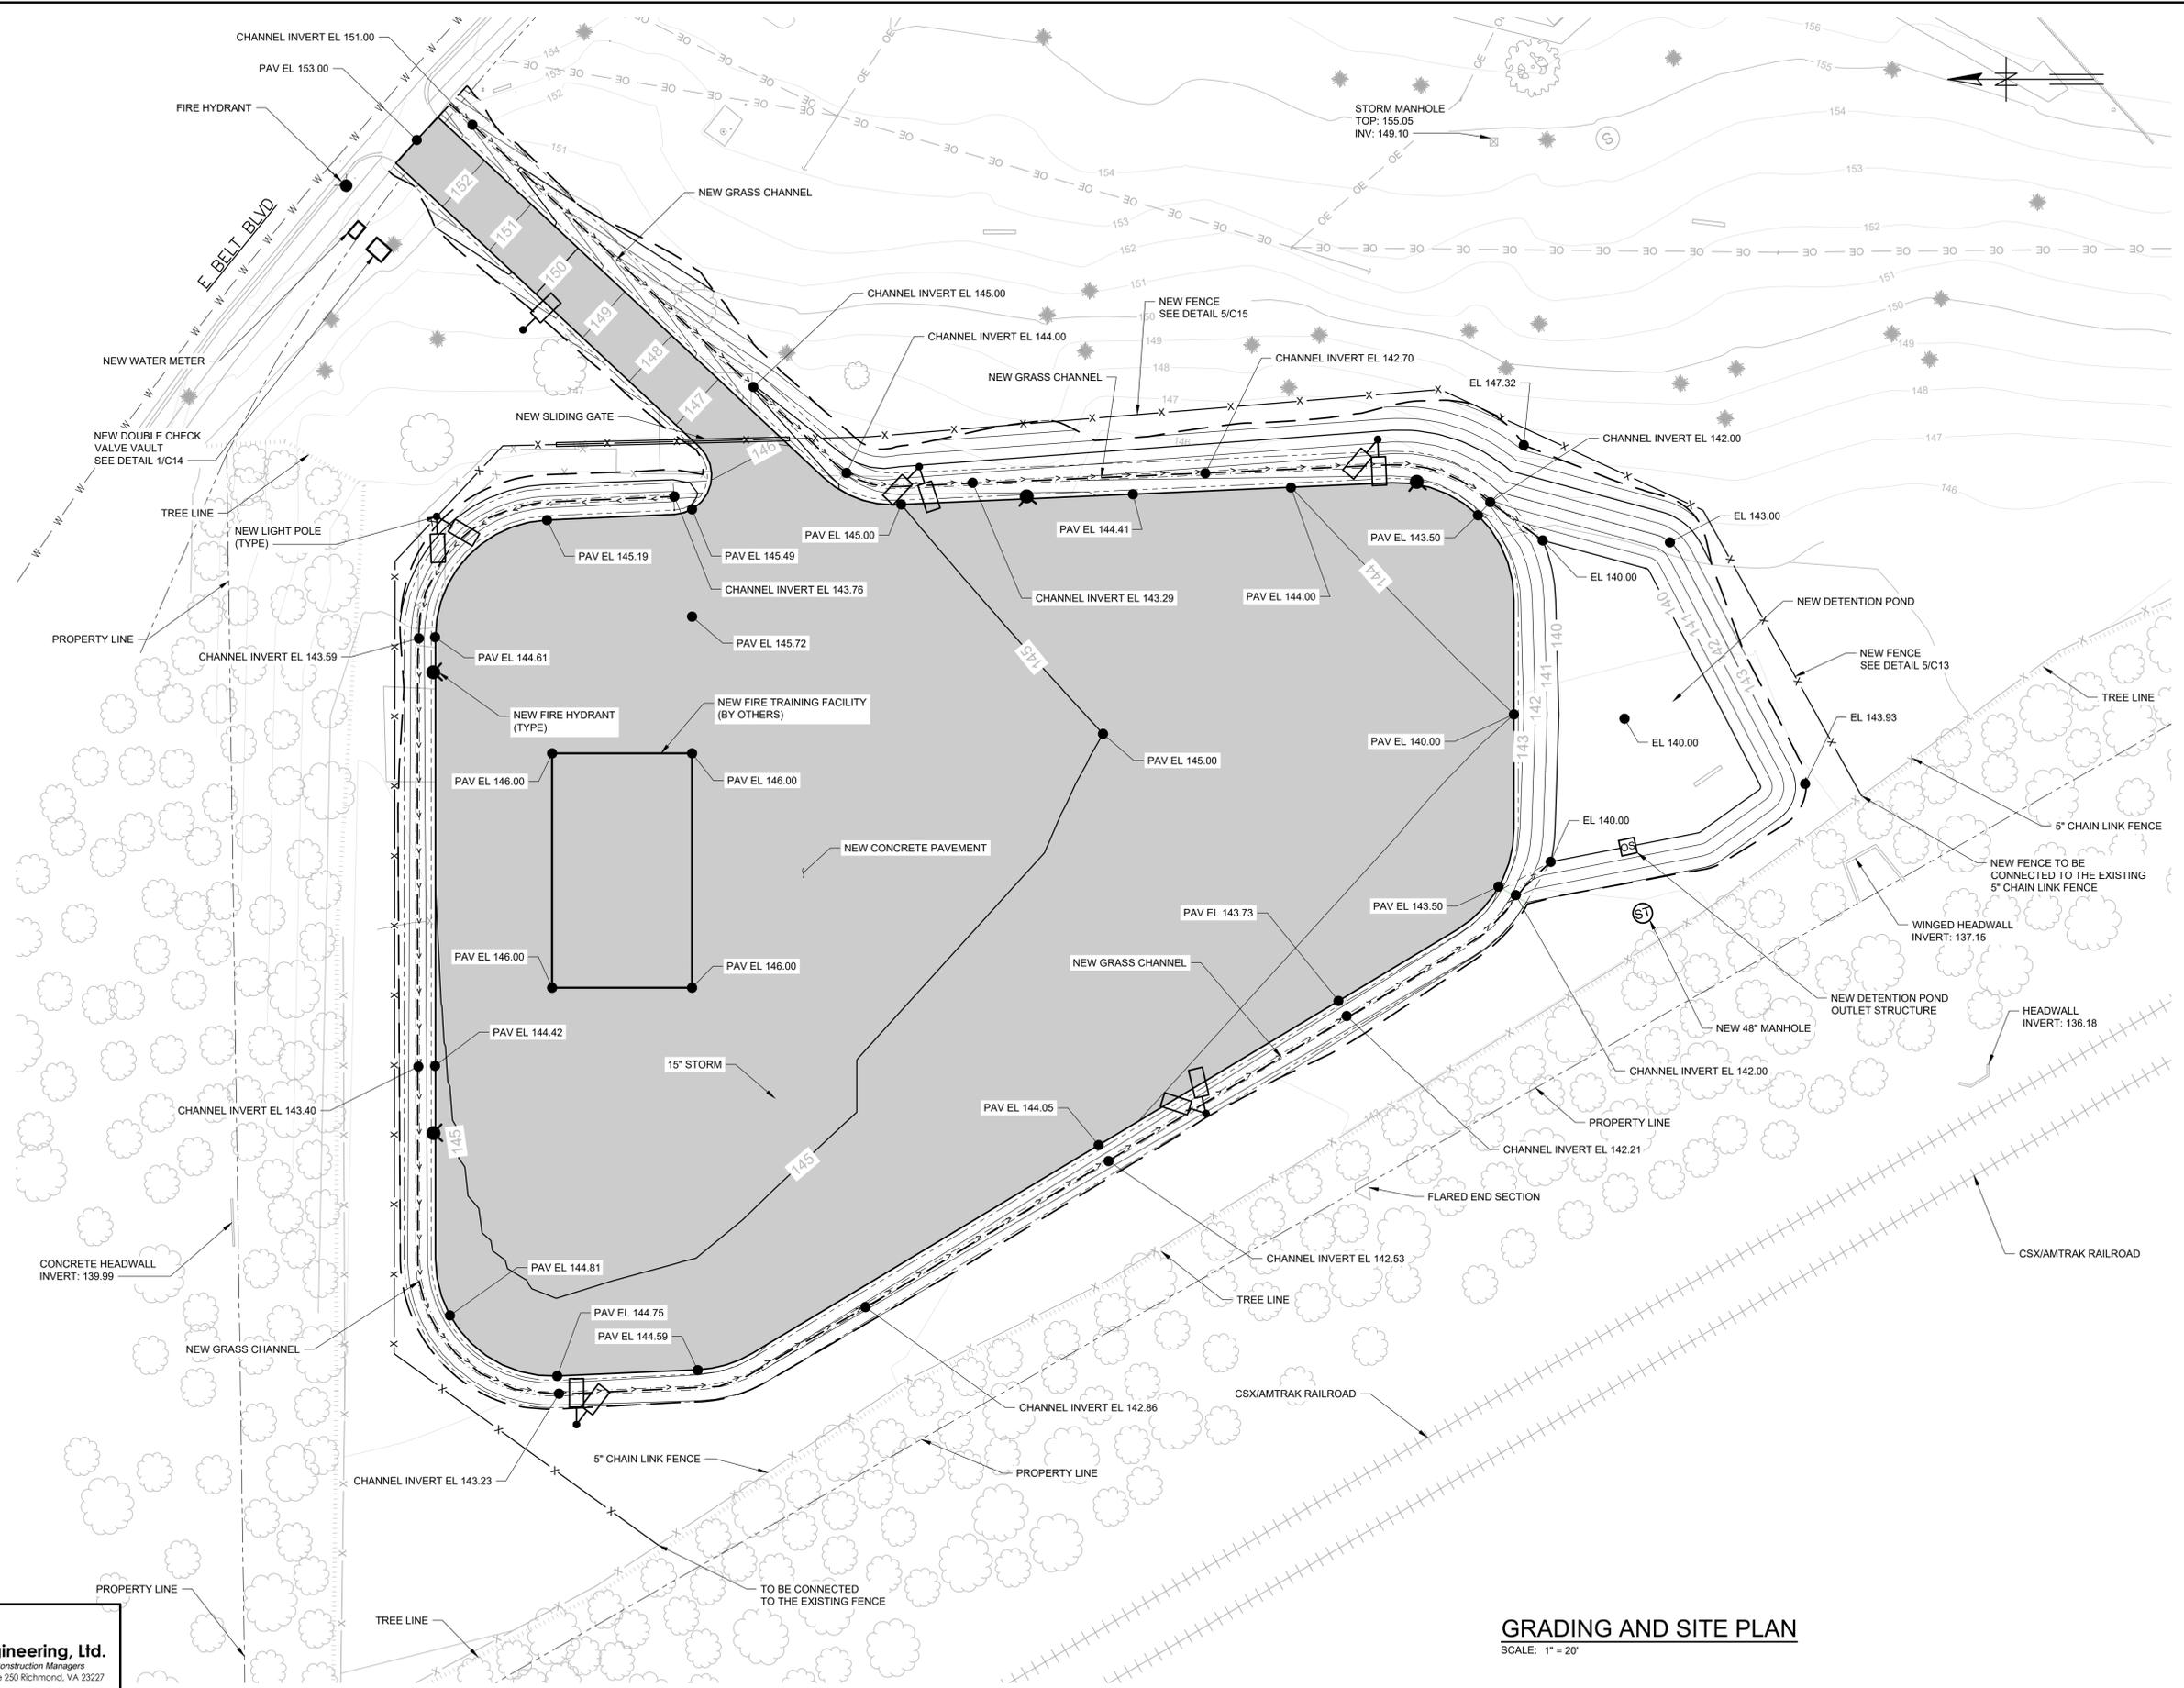

**GRADING AND SITE PLAN**  
SCALE: 1" = 20'

**EC** **Environ-Civil Engineering, Ltd.**  
Engineers • Scientists • Construction Managers  
2108 W Laburnum Avenue, Suite 250 Richmond, VA 23227

**GREELEY AND HANSEN**  
9020 STONY POINT PARKWAY, SUITE 275  
RICHMOND, VIRGINIA 23235

DESIGNED	XXX
DRAWN	XXX
CHECKED	XXX
APPROVED	

NO.	DATE	APPD	REVISION DESCRIPTION



CITY OF RICHMOND, VIRGINIA  
DEPARTMENT OF PUBLIC UTILITIES  
**RICHMOND FIRE DEPARTMENT  
TRAINING FACILITY**



CIVIL  
CIVIL SITE GRADING PLAN

PROJECT NO.:	0218A-09
DWG:	<b>C12</b>
SHEET:	14 OF XX
DATE:	NOVEMBER 2022
REV:	0